


PROPOSED FACULTY HOUSING SHOWN FOR REFERENCE ONLY

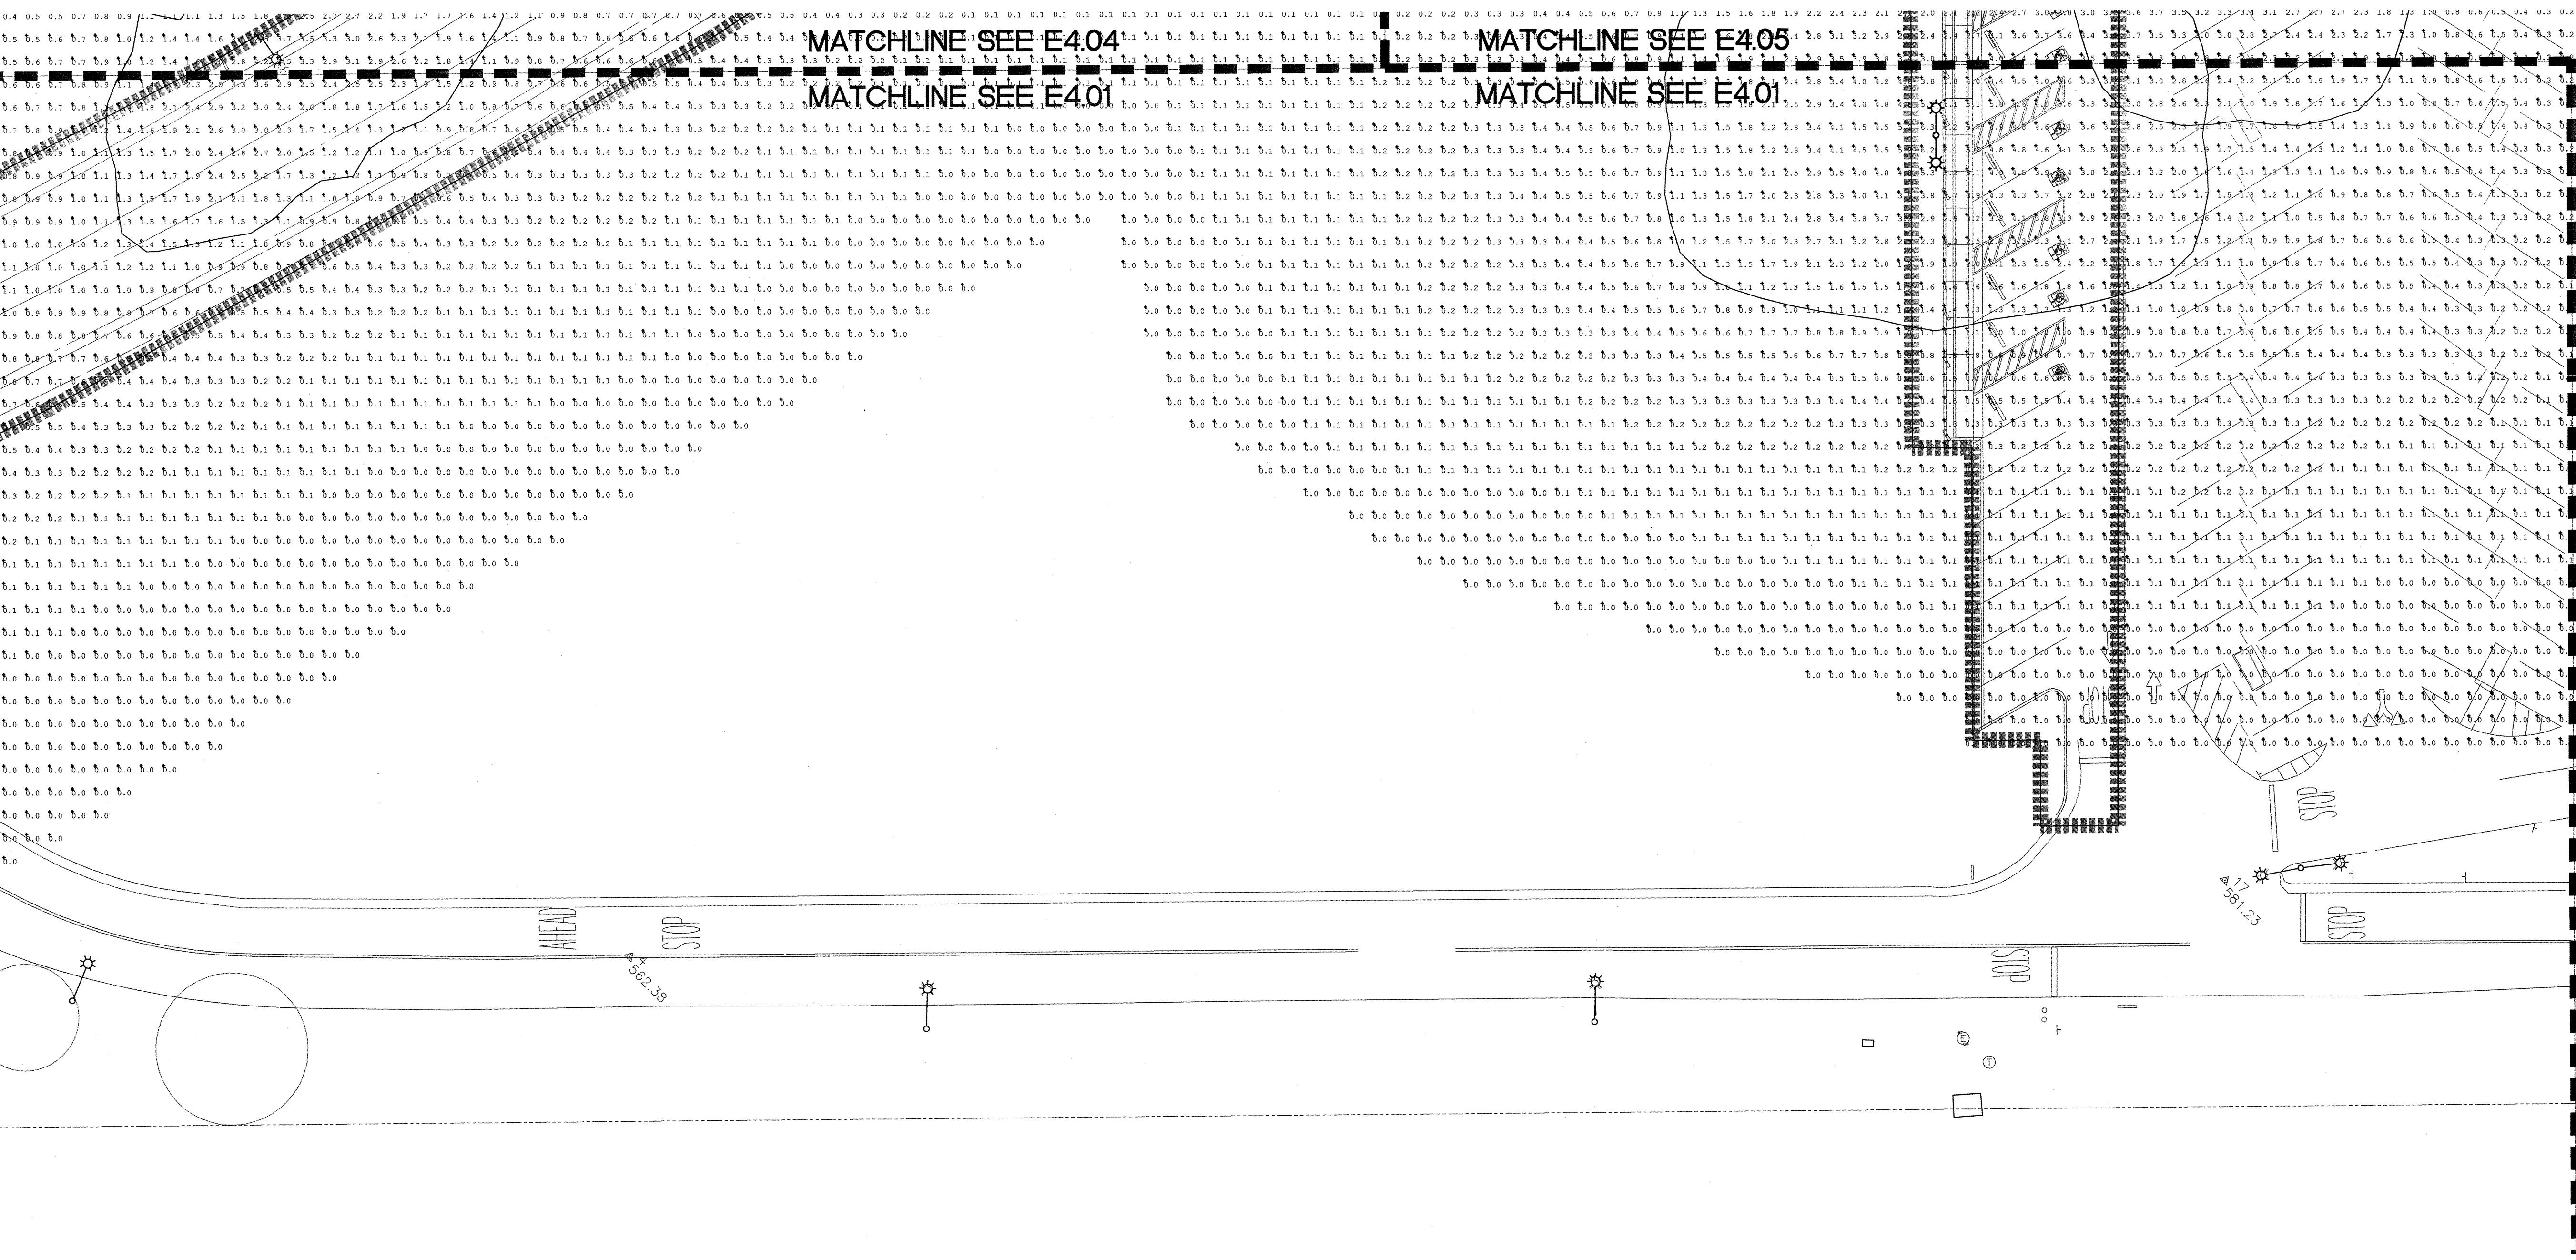

RText (RText)

College of San Mateo

Site Package

Site: San Mateo, CA

Developed for

Revision	Description	Date

revision	Description	Date
	DSA SUBMITTAL	19 SEPT 2008
	DSA FINAL	09 APRIL 2009

40	Job. No.	3000
20	Date	09 APRIL 20
10	Drawn by	REI CAD TEA
0	Checked by	TH/SF/R
0	Scale	AS SHOWN
<p>Site Lighting Plan - Ltg. Extended Photometric</p> <p>E4.01</p>		