


The lighting calculations provided in this report approximate the light levels expected within the space as defined and are based on the information provided to Cal Lighting. Please verify the data to assure the accuracy of the report. Cal Lighting is not responsible for light output of lamps and ballasts, or design variables.

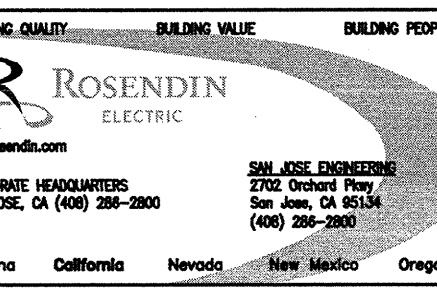

IDENTIFICATION STAMP		
DIV. OF THE STATE ARCHITECT		
OFFICE OF REGULATION SERVICE		
APPL #: 01-110097		
AC	FLS	SS
DATE	APR 09 2009	
FILE NUMBER:		

and the one or other project documents and all notes, estimates and designs incorporated therein are instruments of service. Project documents are the registered property of LPA, INC. (LPA) and cannot be lawfully used in whole or in part for any project or purpose except as described in the contractual agreement between McCarthy and the District. LPA hereby gives formal notice that any such project document use, reproduction or modification (misuse) is not only unlawful but automatically binds all parties involved with misuse to fully indemnify and defend LPA and LPA's Consultants to the maximum legal extent against all losses, demands, claims or liabilities arising directly or indirectly from project document misuse. Project documents describe design, intent of work or are not a representation of as-built or existing conditions. LPA and LPA's Consultants make no representations concerning the accuracy of documents and are not responsible for any discrepancies between project documents and the existing conditions.

© Copyright 2008


College of San Mateo Site Package

Developed for
San Mateo

Revision	Description	Date
DSA	SUBMITTAL	19 SEPT 2008
DSA	FINAL	09 APRIL 2009

Job. No.	300085
Date	09 APRIL 2009
Drawn by	REI CAD TEAM
Checked by	TH/SF/RW
Scale	AS SHOWN

**Site Lighting Plan -
Ltg. Extended
Photometric
E4.07**

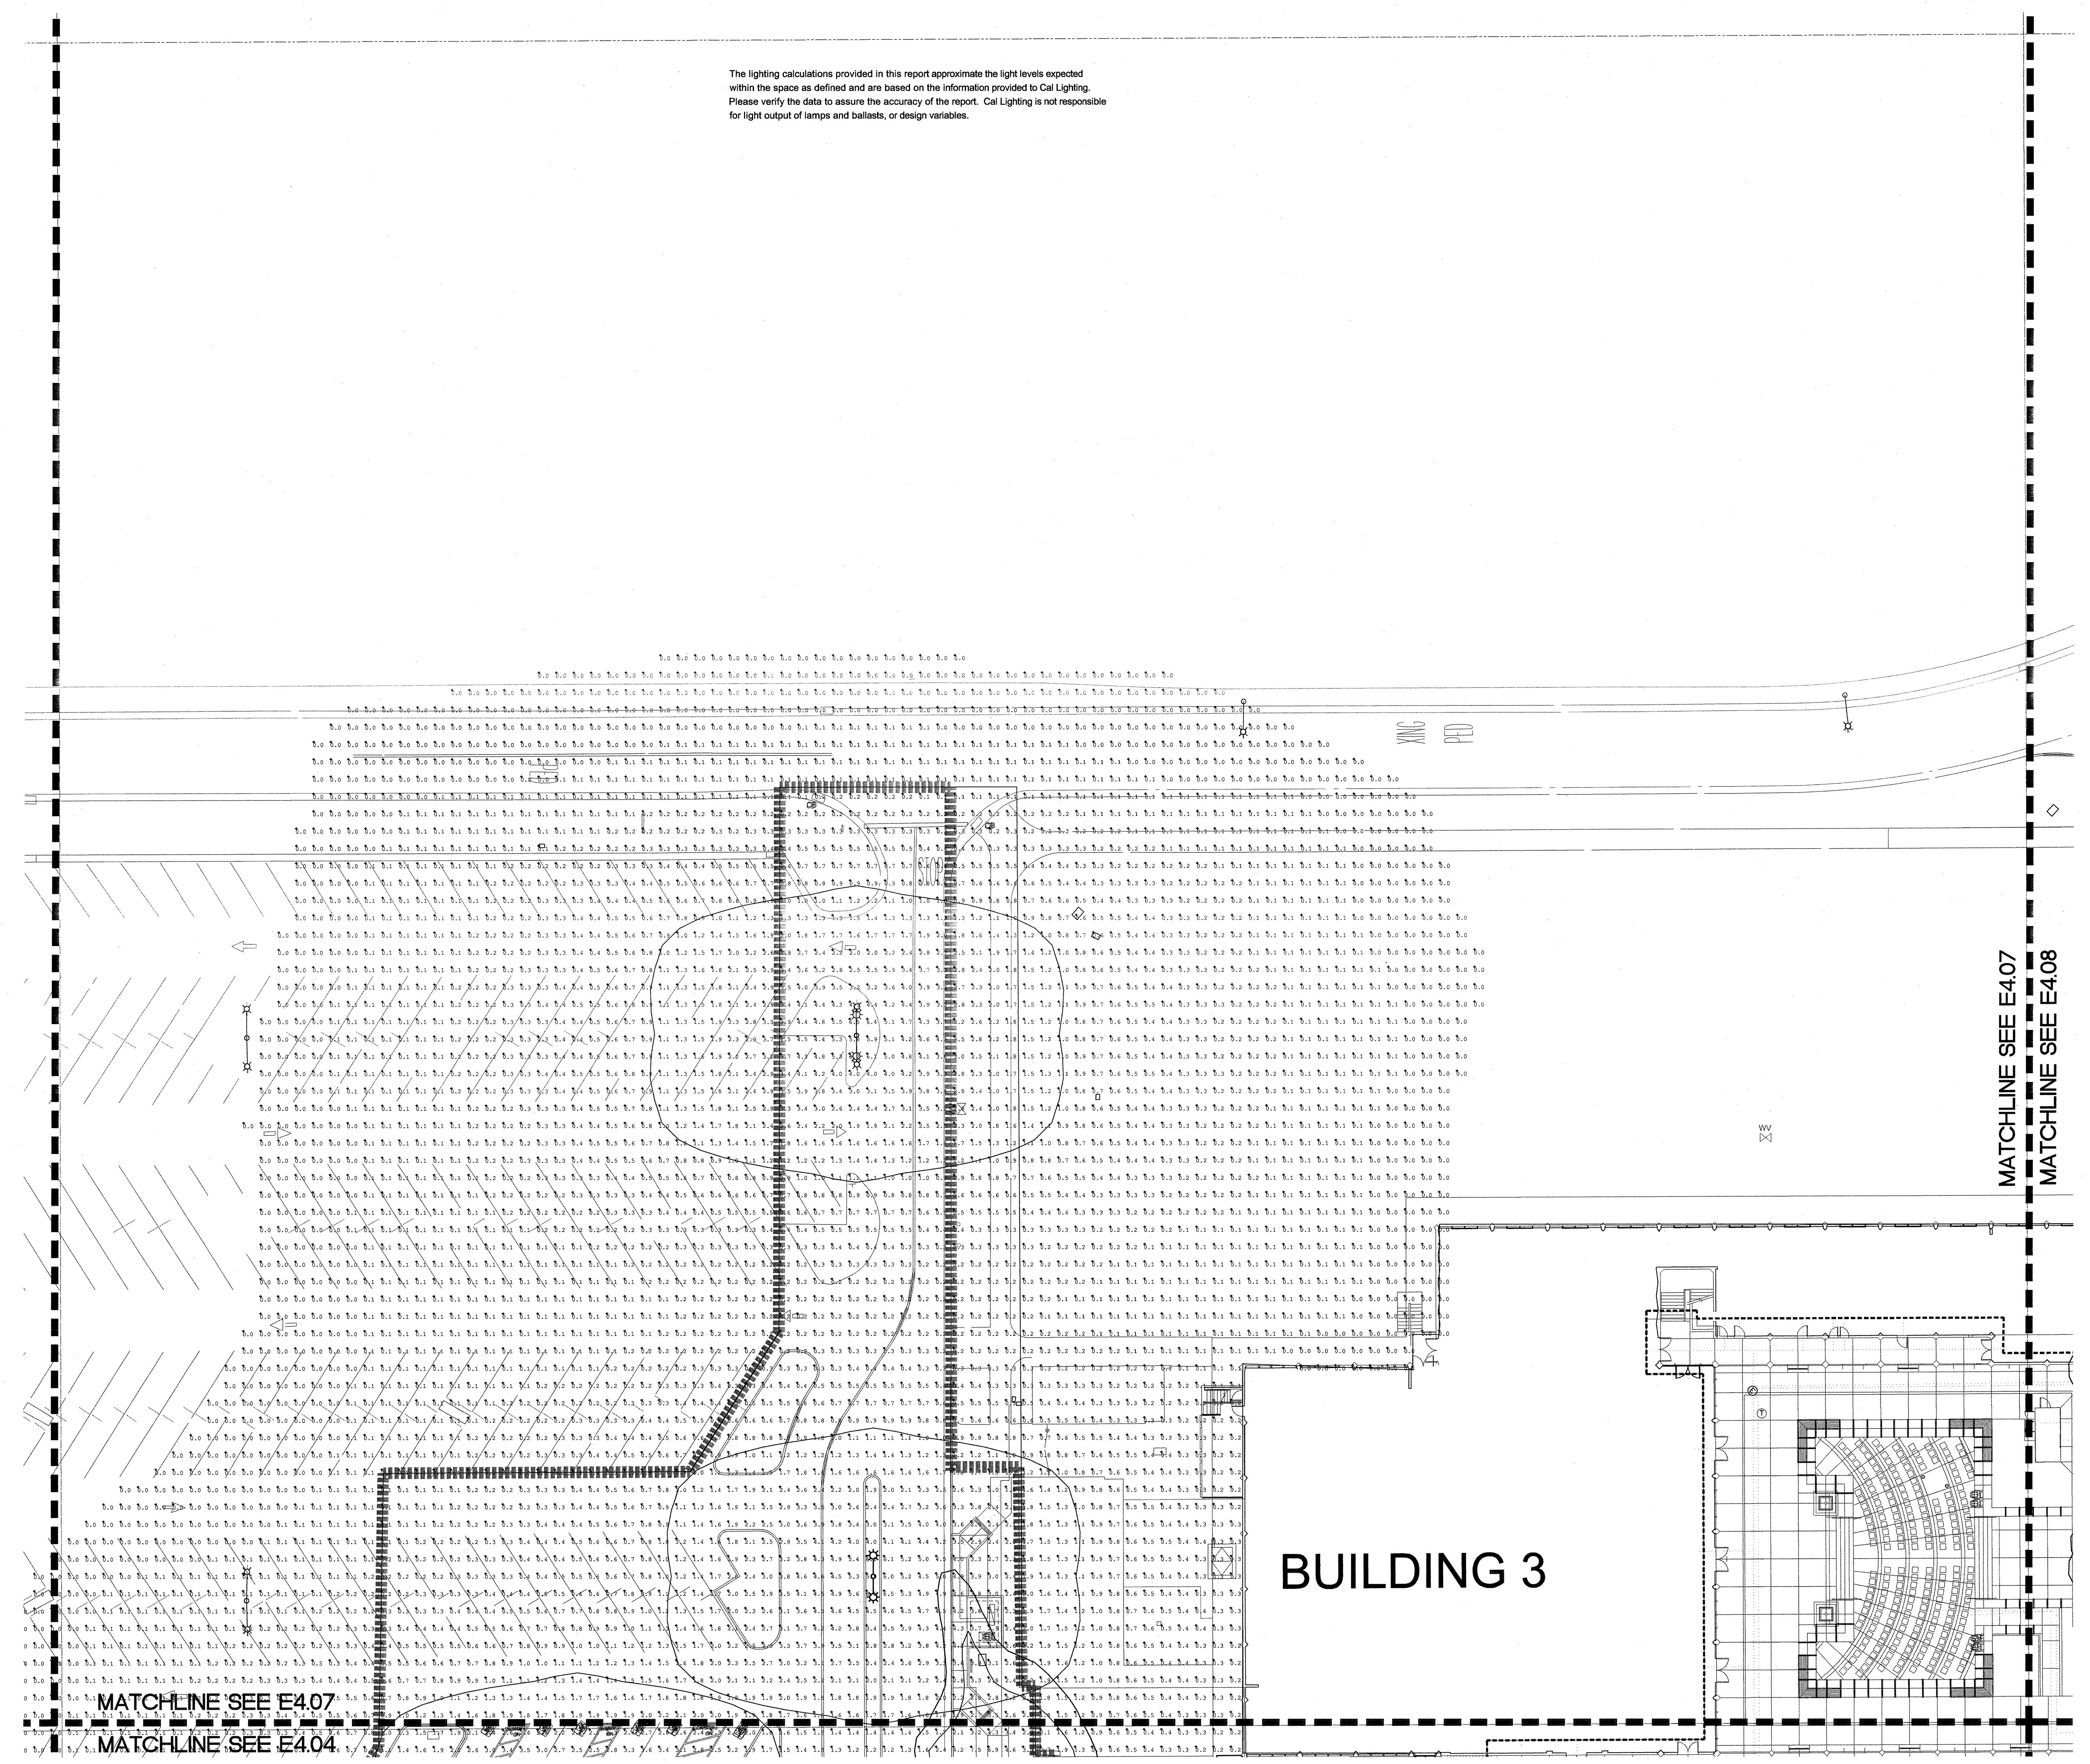

BUILDING 3

RText (RText)