

DOOR NO.	ROOM NO.	ROOM NAME	SIGN ROOM NAME	SIGNAGE TYPE	REMARK
100	4-100	MECHANICAL ROOM	MECHANICAL	D	INLIVIARE
102 104a	4-102 4-104	MEDIUM CLASSROOM CORRIDOR	ELECTRICAL/ELEVATOR	C/X D	
			EQUIP./TDB		
104b	4-104A	ELECTRICAL ROOM	ELECTRICAL	D	
104c 104d	4-104A 4-104B	TDB	ELECTRICAL	D D	
104u 104e	4-104B 4-104C	ELEVATOR EQUIP. RM	ELEVATOR EQUIP.	D	
106	4-106	JANITOR	CUSTODIAL	D	
110a	4-110	LOBBY CLIENT		C1/X	
4401-	4.4400	RECEPTION	NA/ONAFA!	F0/F5	
110b 110c	4-110B 4-110B	WOMEN'S LOCKERS WOMEN'S LOCKERS	WOMEN WOMEN	E2/E5 E2/E5	
110d	4-110C	MATERIAL DISPENSARY	VVOIVILIN	C	X2
110e	4-110D	LAUNDRY		C	X2
110f	4-110A	MEN'S LOCKER	MEN	E1/E4	
110g	4-110A	MEN'S LOCKER	MEN	E1/E4	
110h	4-110E	SUPPLY CLOSET	4 440D/OALINIA	C1	VIF LENGTH
110i	4-110B/SA UNA	SAUNA	4-110B/SAUNA	С	
110j	4-110A/SA UNA	SAUNA	4-110A/SAUNA	С	
120a	4-120	EST LAB		С	
120b	4-120	EST LAB		С	
120c	4-120A	DISPENSARY STORAGE		С	
120d 122a	4-120 4-122	EST LAB SPA LAB		C	
122b	4-122	SPA LAB		С	
122c	4-122	SPA LAB		С	
130a	4-130	SPA EST STORAGE		С	
130b	4-130	SPA EST STORAGE		С	
132 134	4-132 4-134	LARGE MEETING FACULTY OFFICE	-	C B1/B2/B/2/B3/X	
134	4-134	FACULTY OFFICE		B1/B2/B/2/B3/X B1/B2/B2/B3/X	
138	4-138	JANITOR	CUSTODIAL	D	
140	4-140	STUDENT RESOURCE		C/X	
142	4-142	STAFF RSTRM	STAFF RESTROOM	E3/E6	
144	4-144	FACULTY RESOURCE		C	
146 148a	4-146 4-148	SMALL MEETING LARGE CLASSROOM		C/X C/K/J	
148b	4-148	LARGE CLASSROOM	CLASSROOM	D/H	EXT GRADE
150	4-150	JANITOR	CUSTODIAL	D	271 01012
152	4-152	MEN'S RSTRM	MEN	E1/E4	
154	4-154	ELEVATOR EQUIP. RM	ELEVATOR EQUIP.	D	
156	4-156	ELEC RM	ELECTRICAL	D	
158 160	4-158 4-160	TDA WOMEN'S RSTRM	WOMEN	D E2/E5	
170a	4-170	LARGE CLASSROOM	VVOIVILIN	C/K/J	
170b	4-170	LARGE CLASSROOM	CLASSROOM	D/H	EXT GRADE
180a	4-180	LARGE CLASSROOM		C/K/J	
180b	4-180	LARGE CLASSROOM	CLASSROOM	D/H	EXT GRADE
191 193	4-191 4-193	CORRIDOR ENTRY LOBBY		O/O1/L O/O1/L	
194	4-193	CORRIDOR		0/01/L	
196	4-196	HHW S&R CLOSET	MECHANICAL	D	
197	4-197	FIRE RISER ROOM	FIRE SPRINKLER RISER	D	EXT GRADE
201a	4-201B	LARGE CLASSROOM		С	
201b	4-201A	MEDIUM CLASSROOM	EL FOTDIO AL	С	
203 205	4-203 4-205	ELEC CLOSET CLIENT RSTRM	ELECTRICAL RESTROOM	D E3/E6	
205 206	4-205	SALON	NEOTINOUIVI	C/X	
207	4-207	STAFF RSTRM	STAFF RESTROOM	E3/E6	
208a 208b	4-208 4-280A	CLIENT RECEPTION FLOOR CNTRL VALVE	FIRE SPRINKLER RISER	C D	
210a	4-210	ROOM FACULTY OFFICE		B1/B2/B2/B3/X	
210b	4-210A	CLOSET		B1	
212 214	4-212 4-214	FACULTY OFFICE FACULTY OFFICE		B1/B2/B2/B3/X B1/B2/B2/B3/X	
214 216	4-214	FACULTY OFFICE	+	B1/B2/B2/B3/X	
218	4-218	MEDIUM CLASSROOM		C/X	
220	4-220	MEN'S RSTRM	MEN	E1/E4	
222	4-222	WOMEN'S RSTRM	WOMEN	E2/E5	
224a 224b	4-224 4-224A	ADMIN WORK ROOM		C/X C	
230a	4-224A 4-230	HAIR LAB: SENIOR	+	C2	
230b	4-230A	RECEPTION DESK		C	
230c	4-230B	DISPENSARY		С	
230d	4-230D	LAUNDRY		С	
230e 230f	4-230	HAIR LAB: FRESHMEN		C	
230g	55			_	
240a	4-240	HOSTING GALLERY		C1/X/O/O1/L	EXT GRADE
240b	4-240A	SMALL MEETING		C/X	
240c	4-240B	WORK KITCHEN ROOM		C	
240e	4-240	HOSTING GALLERY CORRIDOR		C/X/O1	
241a	4-241		The state of the s		i.

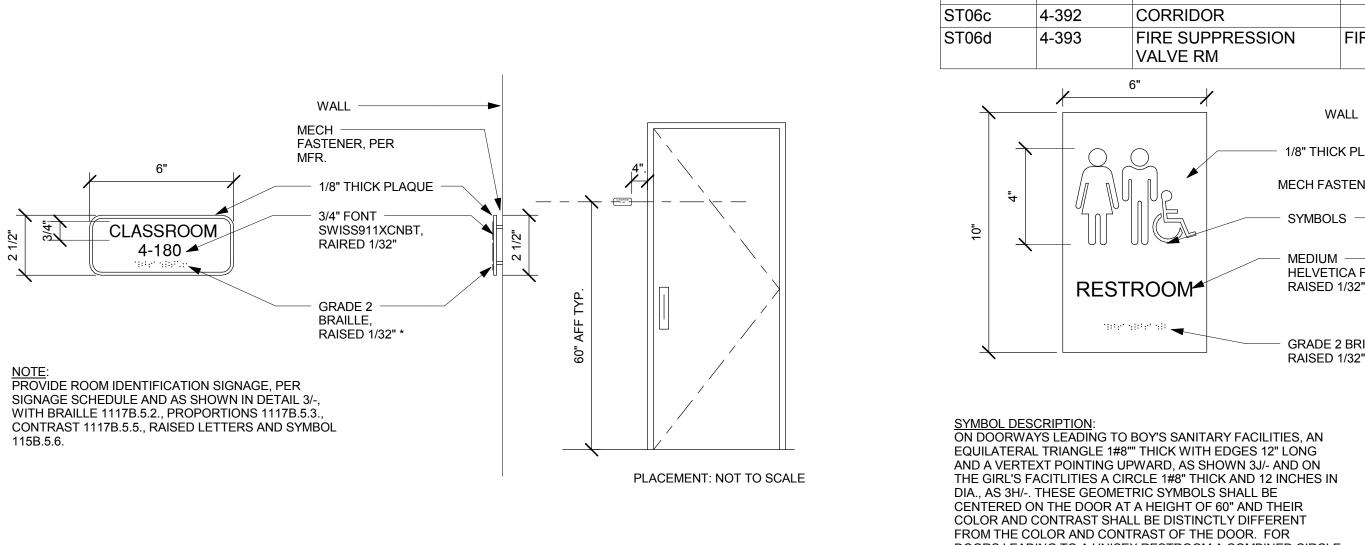


3 TYPICAL ROOM SIGNAGE DETAIL



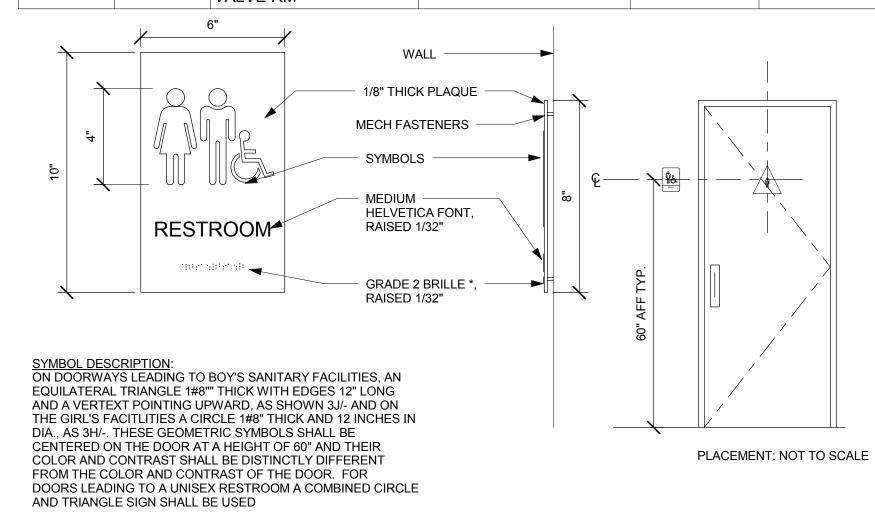

2 RESTROOM SIGNAGE DETAIL
3" = 1'-0"

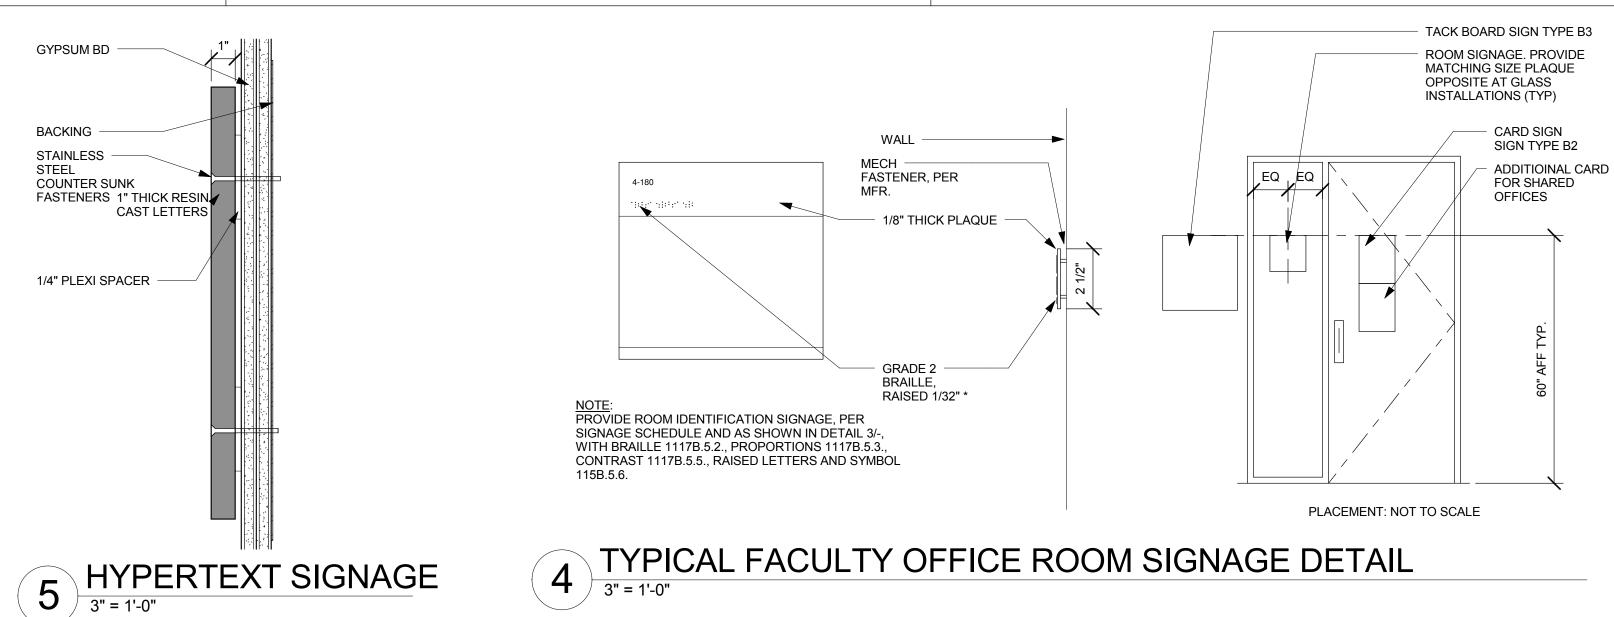

NOTE: ALL SIGNAGE MOUNTED ON GLASS SHALL HAVE MATCHING COVER

OPPOSITE OF GLASS

E1


1' - 0"


/ 1" HIGH TEXT

WITH 1/4"

 3/4"H TEXT, BRAILLE AT BOTTOM OF SIGN


C2 ROOM NUMBER

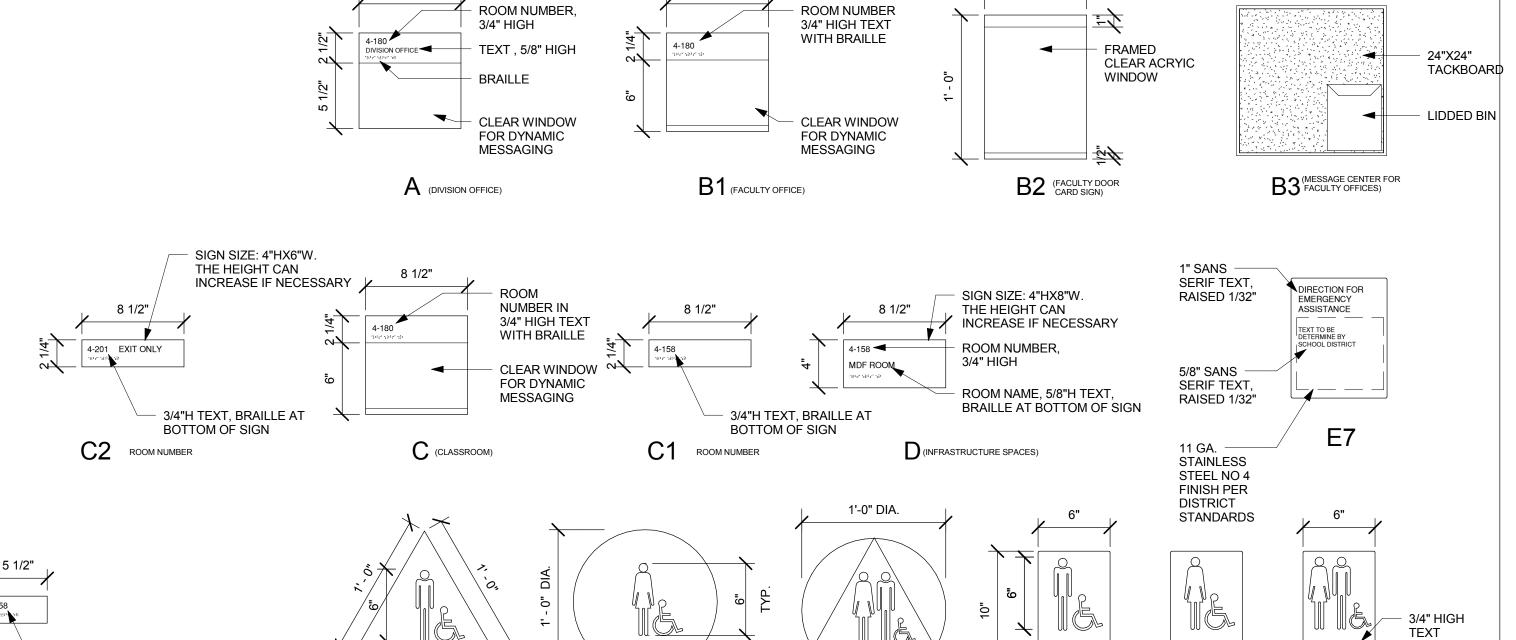

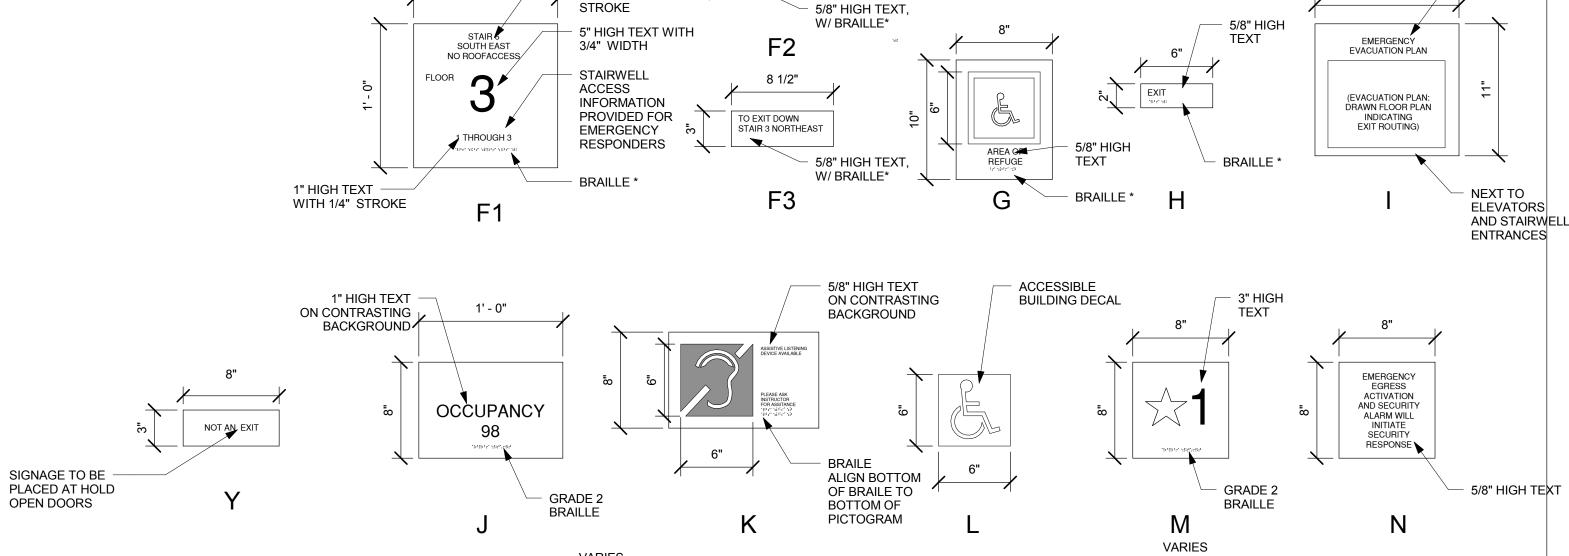

8 1/2"

TO EXIT DOWN STAIR 6 SOUTHEAST

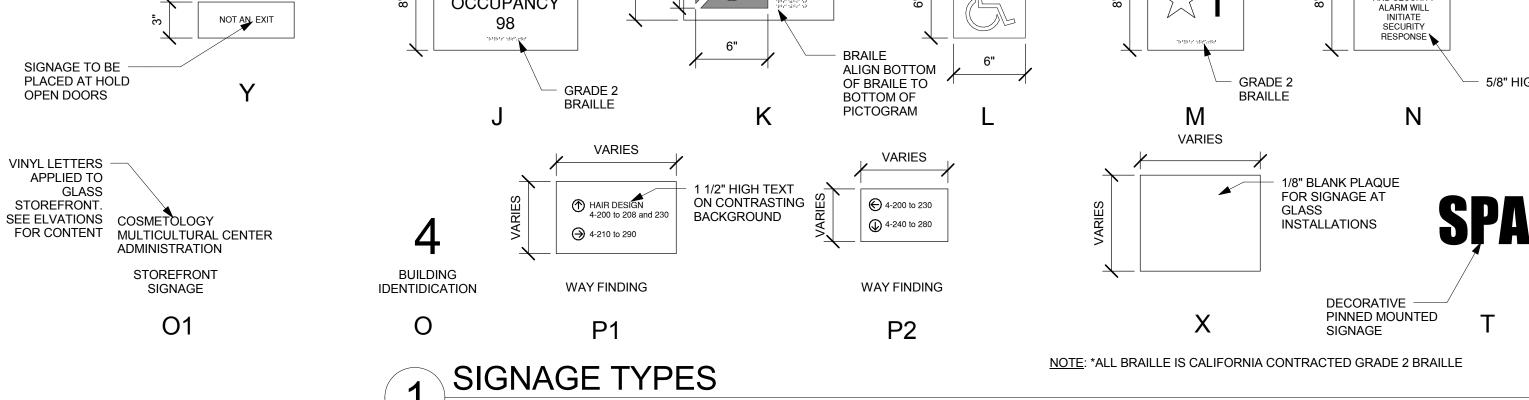

SEE PLAN	4-191	CORRIDOR	P1-B/P1-0	
SEE PLAN	4-194	CORRIDOR	P1-A	
SEE PLAN	4-291	ENTRY LOBBY	P2-A	SIGN WIDTH 12". SEE 1B/A-504
SEE PLAN	4-292	CORRIDOR	P2-B	SEE 2A/A-504
SEE PLAN	4-293	ENTRY LOBBY	P2-C	SEE 3D/A-504
SEE PLAN	4-294	CORRIDOR	P2-D	

WRNSSTUDIO

501 SECOND STREET
4TH FLOOR, STE. 402
SAN FRANCISCO
CALIFORNIA 94107
415.489.2224 TEL
415.358.9100 FAX
WWW.WRNSSTUDIO.COM

Steinberg Architects



O. ISSUES/REVISIONS DATE

PROJECT RECORD SET

BUILDING 4
SKYLINE COLLEGE
SAN MATEO COUNTY
COMMUNITY COLLEGE
DISTRICT

CIP2 DESIGN-BUILD PROJECT BUILDING 4

PROJECT NO.: 07012.00 DRAWN BY: Author

DATE: 11/11/08 CHECKED BY: Checker

SCALE: As indicated

SIGNAGE SCHEDULE

SHEET NO:

A-901

WOMEN

E5

E4

RESTROOM

E6

1' - 0"

BRAILLE *

5/8" HIGH