CENTER FOR ADVANCED LEARNING TECHNOLOGY San Mateo County Community College District


ARCHITECT & CONSULTANTS


KRUGER BENSEN ZIEMER ARCHITECTS, INC. 30 WEST ARRELLAGA STREET SANTA BARBARA, CA 93101 TEL: (805) 963-1726 FAX: (805) 963-2951 EMAIL: kbz@kbzarch.com STEVE DOWTY PRINCIPAL IN CHARGE GERALD SHUSTA PROJECT ARCHITECT

RINNE & PETERSON STRUCTURAL ENGINEERS 1121 SAN ANTONIO ROAD, SUITE C200 PALO ALTO, CA 94303 TEL: (650) 428-2860 FAX: (650) 428-2861 DONALD PETERSON STRUCTURAL ENGINEER

MECHANICAL ENGINEERING CONSULTANTS 621 WEST MICHELTORENA STREET, SUITE A SANTA BARBARA, CA 93101 TEL: (805) 957-4632 FAX: (805) 957-4634 EMAIL: mec@meceng.com ANGELIKA VON ROOS MECHANICAL ENGINEER

ELECTRICAL: DALAN ENGINEERING, INC. 8638 DARBY AVENUE NORTHRIDGE, CA 91325 TEL: (818) 772-2220 FAX: (818) 772-2239 EMAIL: dalan@dalaneng.com MIKE MODUGNO ELECTRICAL ENGINEER

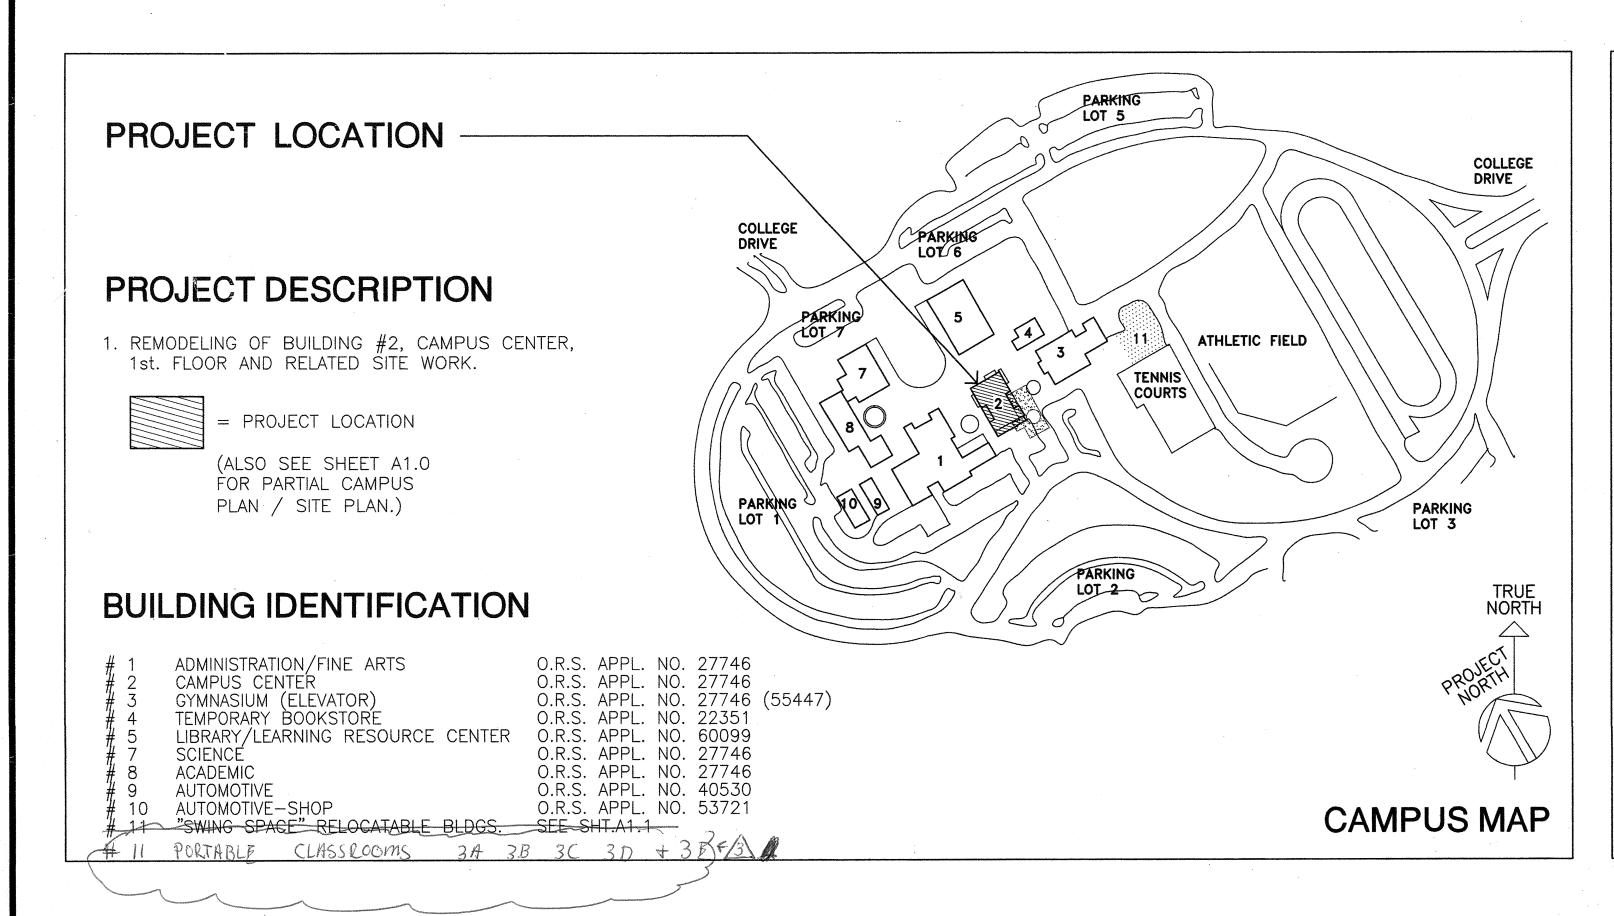

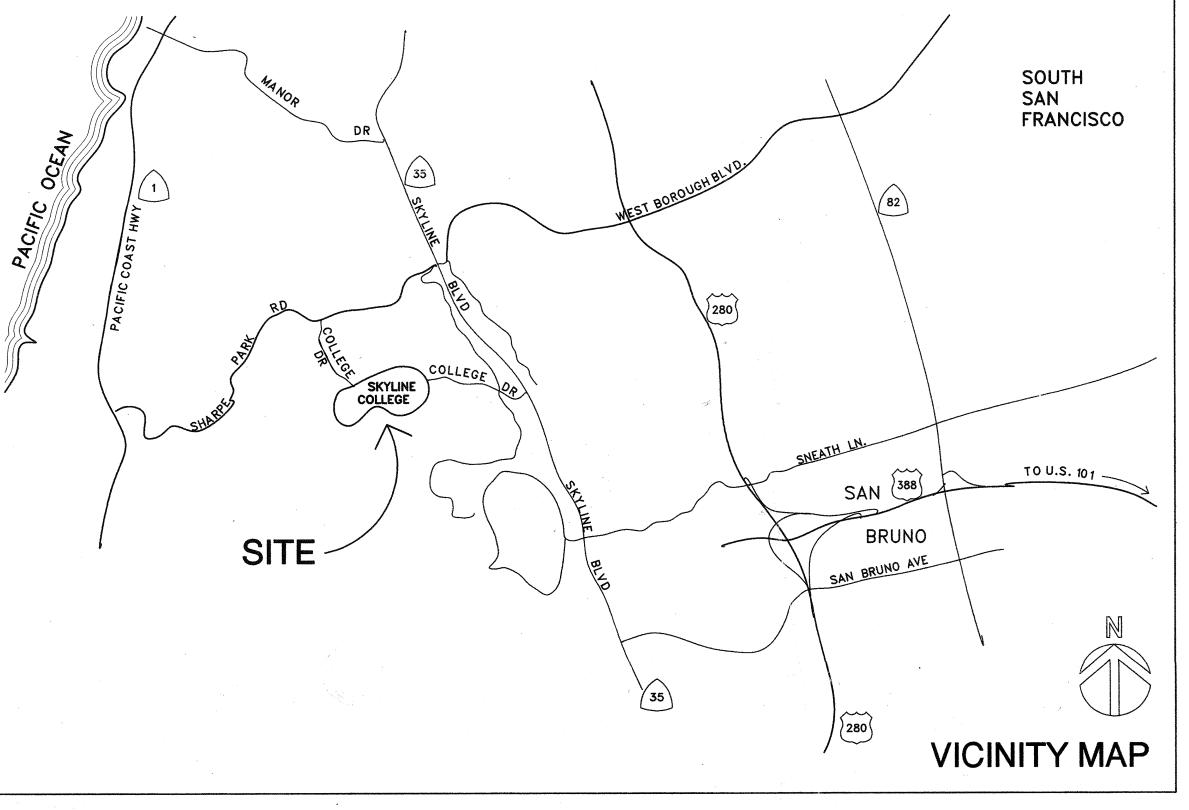

SHEET INDEX

ARCHITECTURAL:

A 0.1 SYMBOLS, ABBREVIATIONS, PROJECT & CODE DATA A 1.0 PARTIAL CAMPUS PLAN / SITE PLAN A 1.1 SLOPING WALK PLAN & DETAILS A 2.0 FLOOR PLAN: EXISTING W/ DEMOLITION PLAN A 2.1 FLOOR PLAN: REMODEL FLOOR PLAN A 2.2 REFLECTED CEILING PLAN A 2.3 FURNITURE PLAN A 3.0 EXTERIOR ELEVATIONS A 3.1 BUILDING SECTIONS A 4.0 DOOR & FRAME SCHEDULE A 4.1 ROOM FINISH SCHEDULE A 5.0 INTERIOR ELEVATIONS A 5.1 INTERIOR ELEVATIONS

A 0.0 SHEET INDEX, ARCHITECT & CONSULTANTS

VICINITY & CAMPUS MAPS, PROJECT DESCRIPTION

A 5.2 INTERIOR ELEVATIONS A 5.3 INTERIOR ELEVATIONS A 9.0 SUSPENDED CEILING DETAILS A 9.1 CEILING DETAILS

A 9.2 WALL DETAILS A 9.3 DOOR & FRAME DETAILS A 9.4 INTERIOR DETAILS

STRUCTURAL:

S 1.0 OPERABLE WALL TRACK DETAILS

MECHANICAL: M 1.1 ABBREVIATIONS, SYMBOLS, & SCHEDULES M 2.1 MECHANICAL DEMOLITION FLOOR PLAN M 2.2 OVERALL MECHANICAL FLOOR PLAN - BLDG #2 M 2.3 PARTIAL MECHANICAL FLOOR PLAN - SOUTHWEST M 2.4 PARTIAL MECHANICAL FLOOR PLAN - SOUTHEAST M 2.5 PARTIAL MECHANICAL FLOOR PLAN - NORTHEAST M 2.6 PARTIAL MECHANICAL FLOOR PLAN - NORTHWEST M 2.7 MECHANICAL ROOM PLAN & PARTIAL PIPING PLAN M 2.8 ROOF MECHANICAL & DEMOLITION PLAN BLDG #2 M 3.1 ABBREVIATIONS, SYMBOLS, & SCHEDULES

PLUMBING

P 1.1 TOILET ROOM PLUMBING AND DEMOLITION PLANS


M 4.1 CHILLED WATER PIPING SCHEMATIC


M 5.1 CONTROLS SCHEMATICS


ELECTRICAL:

E 1.0 SYMBOLS, DETAILS,& SHEET INDEX E 1.2 FLOOR PLAN: EXISTING W/ DEMOLITION PLAN E 2.2 REMODEL FIRST LEVEL LIGHTING FLOOR PLAN BUILDING #2 E 2.3 REMODEL FIRST LEVEL POWER FLOOR PLAN BUILDING #2 E 2.4 COMMUNICATION PLAN BUILDING #2 E 2.5 LOWER ROOF PLAN

E 5.1 PANEL SCHEDULES E 5.2 SINGLE LINE DIAGRAM & FIXTURE SCHEDULE

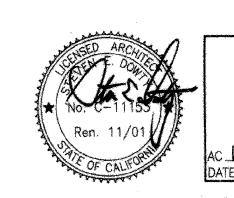

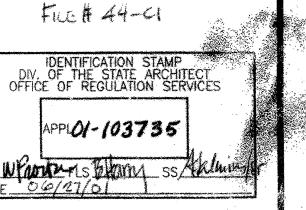

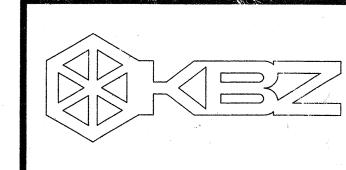

STEVE DOWTY, A.I.A.

Oa

DESCRIPTION

CHECKED 3/21/01 98-03 JOB NO. SHEET TITLE SHEET INDEX, ARCHITECT & CONSULTANTS. **VICINITY & CAMPUS MAPS,** PROJECT DESCRIPTION

A 0.0

SHEET *