


1a) Occupancy Sensor - Wall Mounted

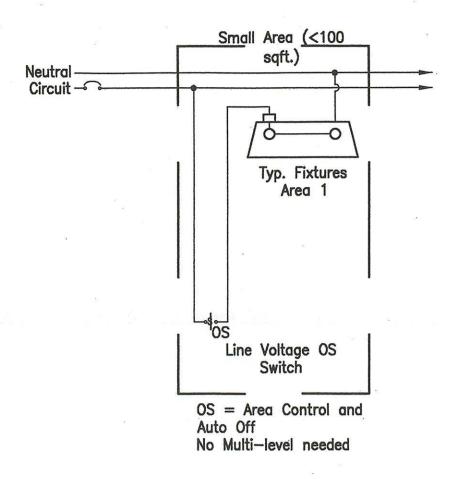


1b) Occupancy Sensor - Ceiling Mounted

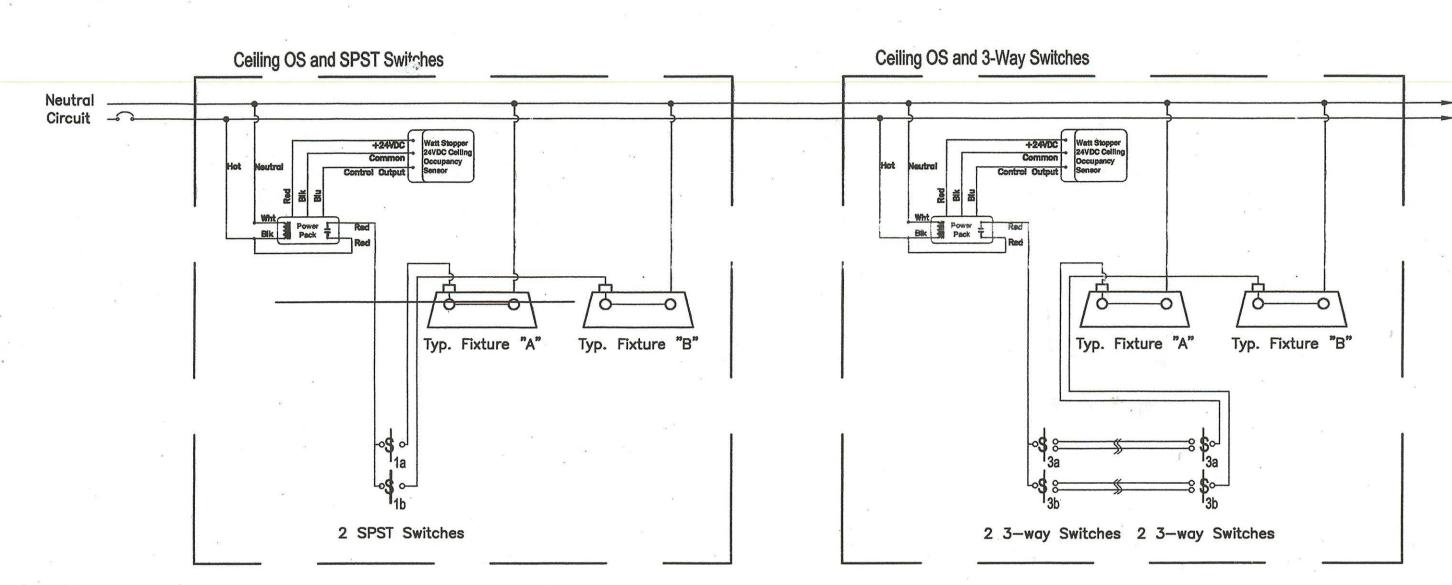


2a) Relay Panel - Low Voltage Switch

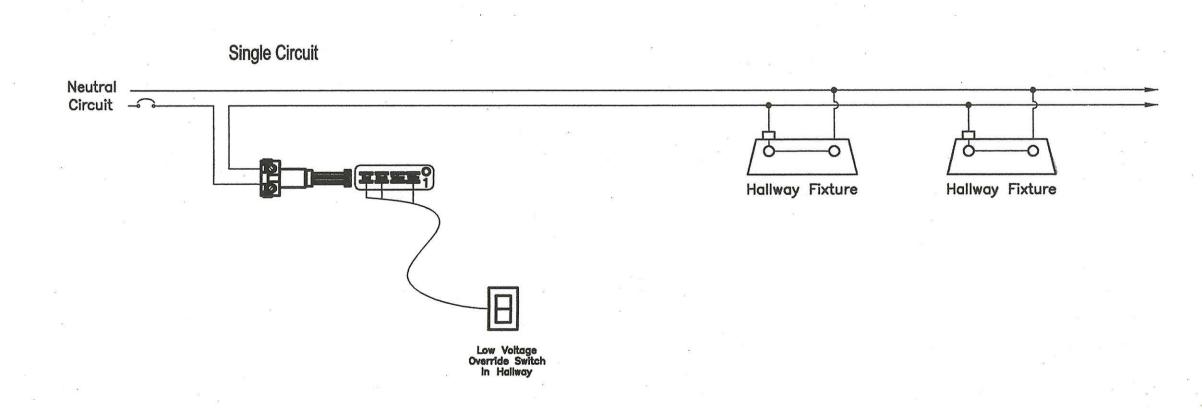

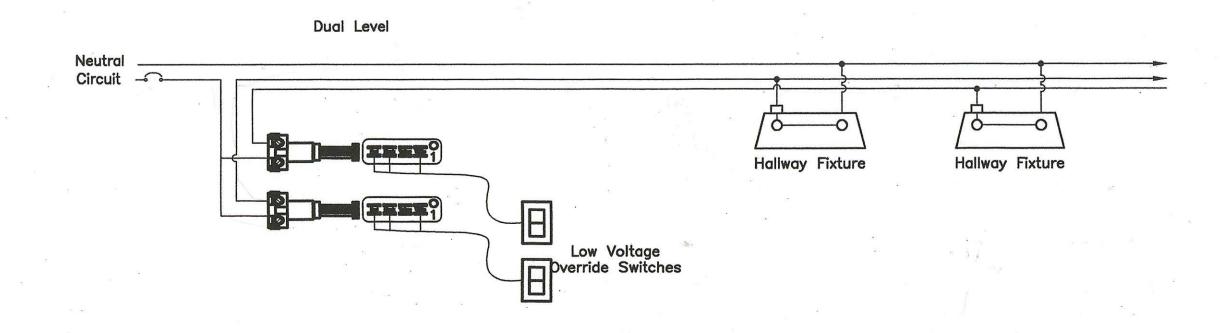

PANEL "7LCP" 8-RELAY CAPACITY PANEL

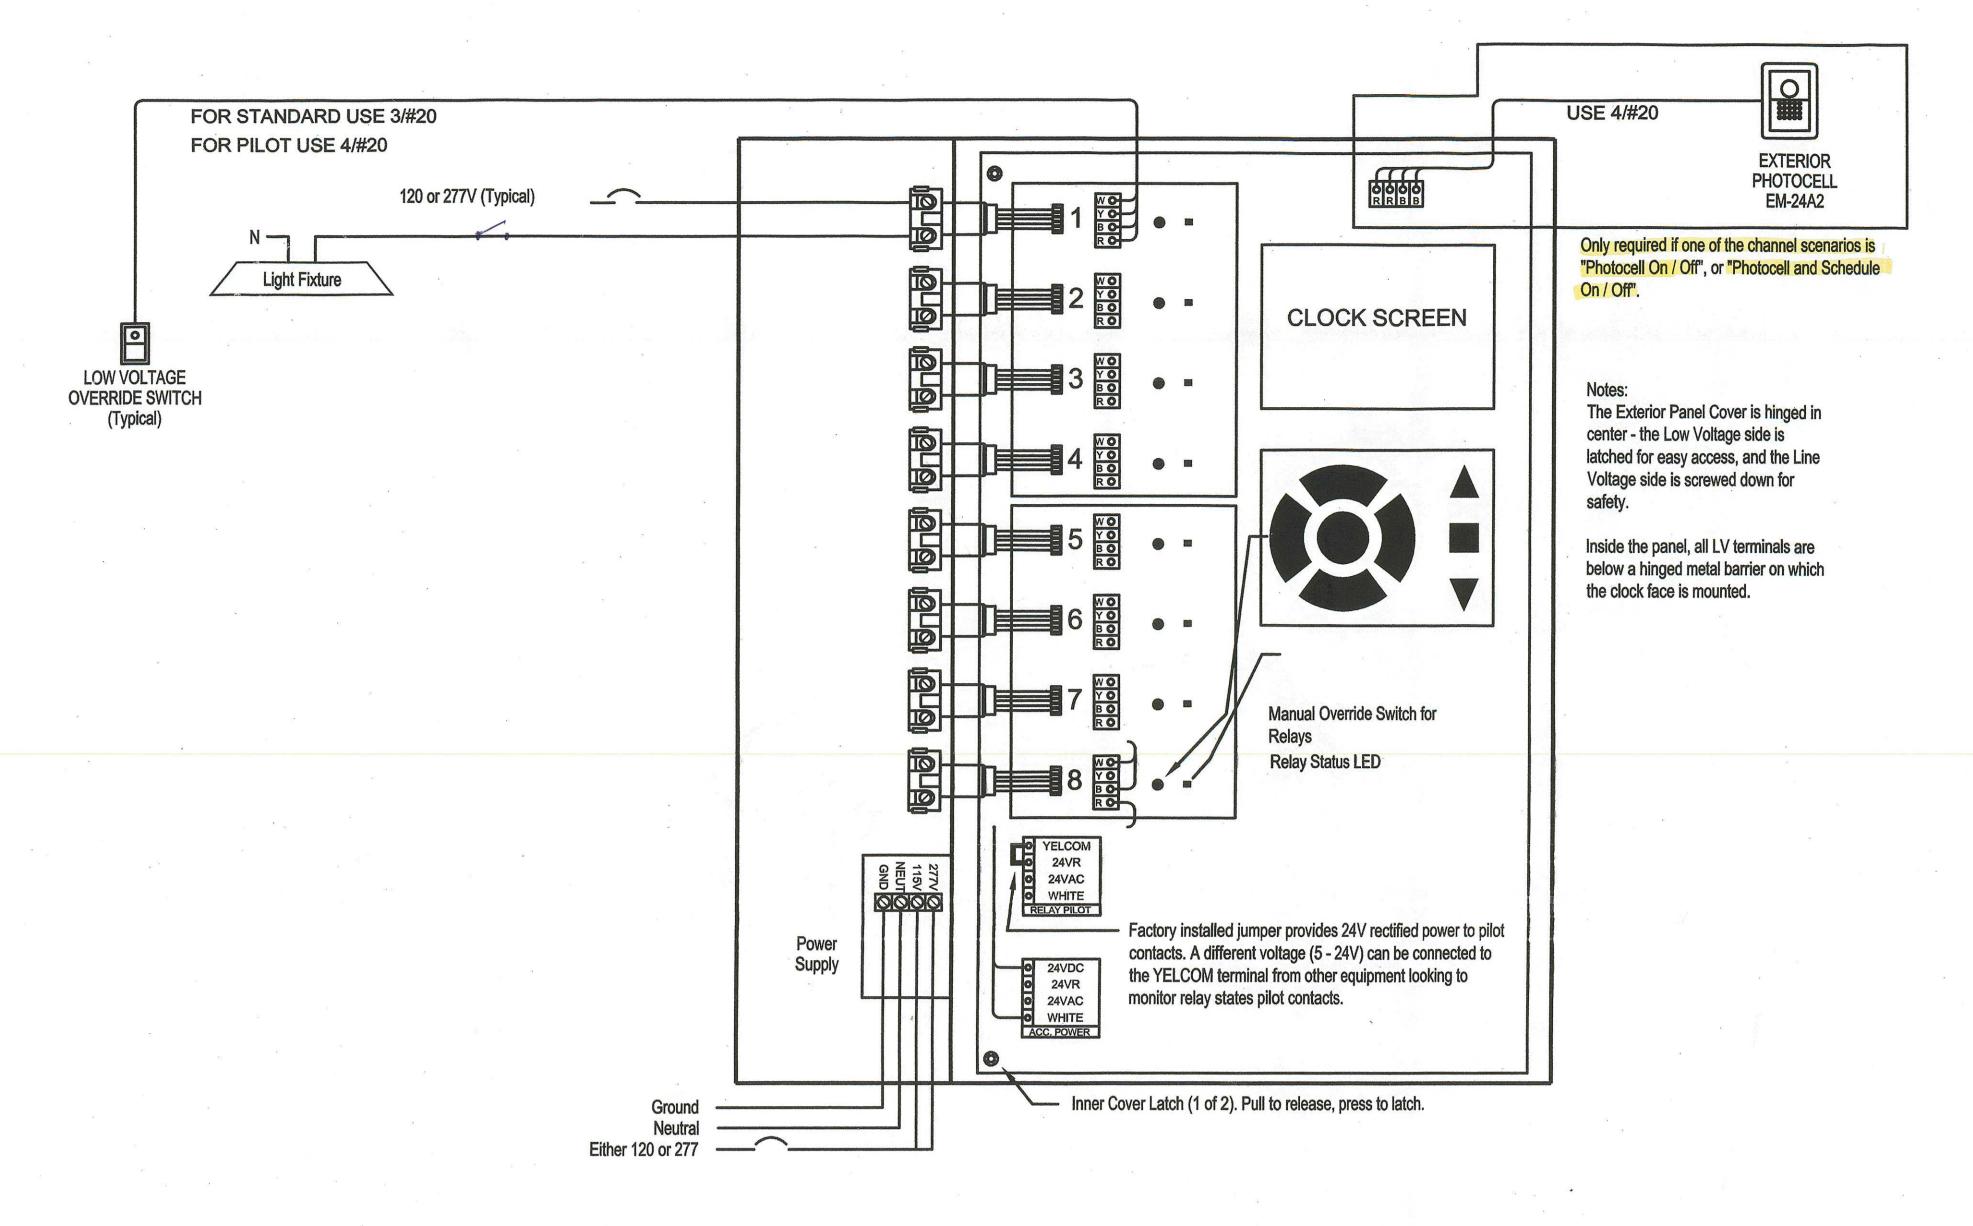

Lighting Control Panel Schedule

LCP Name: Location: Surface/Flush: Power Circuit:		7LCP Electric Room 7112 Surface 7L-24							
					Relay#	Circuit	Description	LV Switch/Sensor	Channel
					1	7L-7	Corridor, Floor 1	LV Switch x	A
2	7L-9	Corridor, Floor 2	LV Switch y	A					
3	7L-11	Corridor, Floor 3	LV Switch z	A					
4	7L-13	Ext. Lights	LV Switch e	D					
(5)	7L-5	Utility Room Lights	LV Switch	Æ					
6	7L-19	Roof Lights (2nd Floor)	LV Switch f	D					
7	7422	Roof Access Light	LV Switch g	D					
8	SPARE	SPARE		-					

LCP Channel Automation Schedule

Channel	Scenario *	Scenario Times	Flick?	Time Delay
Α	2	7:00am - 9:00pm M-F	Yes	120 Min.
В				
С				
D	6	Astro On / Off	No	na
· E	7	Astro On / 11:00pm Off	No	na
F	Name of the second		· ·	
G				4
Н				

Scenario Listings
(1) Manual On / Sched Off
(2) Scheduled On/Off
(3) Manual ON / AS Switch Off
(4) Photocell On/Off
(5) Photo & Sched On/Off
(6) Astronomic On/Off
(7) Astro and Sched On/Off

pecifications:

Provide a single relay panel with up to 8 relays. Each relay to be individually scheduled through an easy to use integral clock with a backlit 8-line LCD display. Relays are to be SPST 20 Amp rated, mechanically held contactors capable of switching either 120 or 277VAC loads. Mounted next to each relay should be a LED to annunciate status and a pushbutton to toggle the relay's state. Panel shall have a multitap transformer and accept either 120V or 277V for power.

Panel enclosure to be NEMA 1, rated for environments from 32 - 139°F, 5 - 95% RH non-condensing. Panel to come with a split cover hinged in the center such that the high voltage side must be unscrewed to access the relays, but the low voltage side can be opened via a locking latch. Surface or flush covers shall be available.

Each relay can be controlled remotely by external switches or motion detectors. Switches can be 2- or 3-wire, momentary or maintained low voltage devices. Motion detectors must provide a 24VDC pilot signal to control the relays. Panel must be able to interlock time based schedules with the occupancy sensor input, so that lights scheduled on during the day are not affected by the motion detector, but after hours the occupancy sensor has control or the relay. Panel shall be capable of blink warning before "OFF" and true after hours time delay.

All programming to be entered via a simple keypad. Each relay can be programmed independently, or relays can be grouped together in firmware to follow the same channel schedule. On a daily 7-day repeating basis, relays can be assigned to follow any of the following scenarios:

- (1) Manual On / Sched Off
- (2) Scheduled On/Off
 (3) Manual ON / AS Switch Off (for use with AS-100 switches)
- (4) Photocell On/Off
- (5) Photo & Sched On/Off (6) Astronomic On/Off
- (7) Astronomic On/Off

The LCD screen should normally show the current time and date, as well as sunrise and sunset times for that day. Relay channels can also be monitored from the display to see their status - either ON, OFF, or MIXED. Additionally the relay groups can be overriden from the screen. Context sensitive help shall be available for each screen.

Panel to be The Watt Stopper's (800-852-2778) LP8 panel and must be UL Listed 916, meet local energy codes (California CEC), and have a 1 year warranty.


SKYLINE COLLEGE MODERNIZATION OF BUILDING




STEINBERG ARCHITECTS 60 Pierce Avenue San Jose CA 95110

ALFATECH
CAMBRIDGE


120 MONTGOMERY STREET, SUITE 716 416-403-5000
SAN FRANCISCO, CALIFORNIA 84104 FAX: 416-783-8040
SAN JOSE: SAN FRANCISCO - NEW YORK/NEW JERSEY
LOS ANGELES - PALO ALTO - SINGAPORE - AUSTRALIA
ATCG Project No. 208108

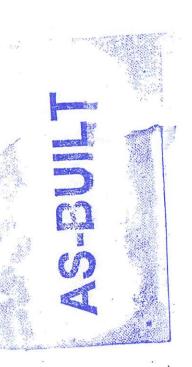



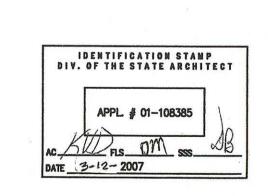

	02.27.07	DSA BACK CHECK
	11.02.06	DSA SUBMITTAL
	10.13.06	75% CD
	09.12.06	40% PROGRESS
rev.	date	issue

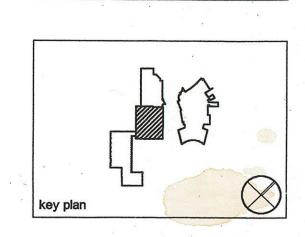

STEINBERGARCHITECTS

project no: 06015 date: 02.27.07

drawn by: MAMP checked by: VB

scale: NONE 0 4 8

E0.02

LIGHTING CONTROL DIAGRAM